

**EXH. DMR-4
DOCKETS UE-22 ___/UG-22 ___
2022 PSE GENERAL RATE CASE
WITNESS: DAWN M. REYES**

**BEFORE THE
WASHINGTON UTILITIES AND TRANSPORTATION COMMISSION**

**WASHINGTON UTILITIES AND
TRANSPORTATION COMMISSION,**

Complainant,

v.

PUGET SOUND ENERGY,

Respondent.


**Docket UE-22 ___
Docket UG-22 ___**

**THIRD EXHIBIT (NONCONFIDENTIAL) TO THE
PREFILED DIRECT TESTIMONY OF**


DAWN M. REYES

ON BEHALF OF PUGET SOUND ENERGY

JANUARY 31, 2022

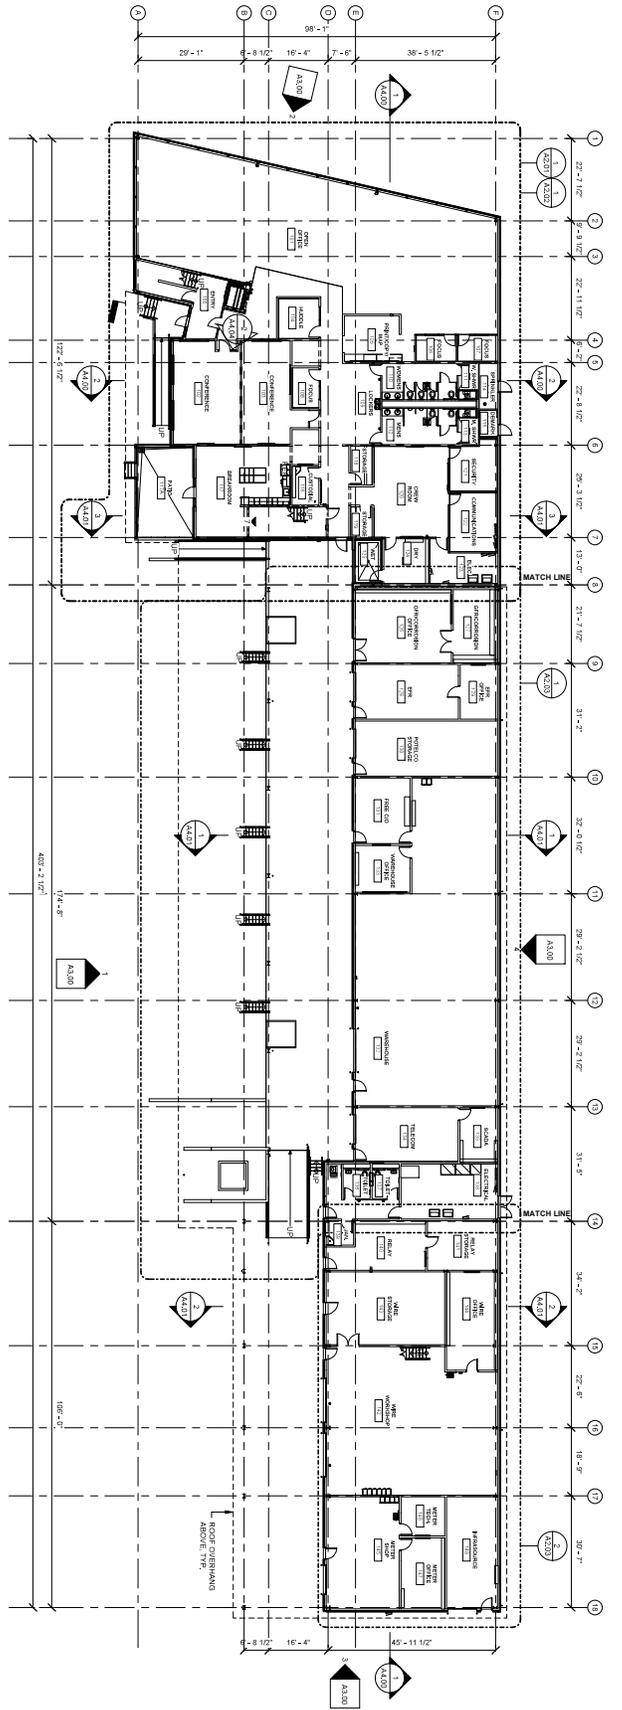

① OVERALL FLOOR PLAN
1/16" = 1'-0"

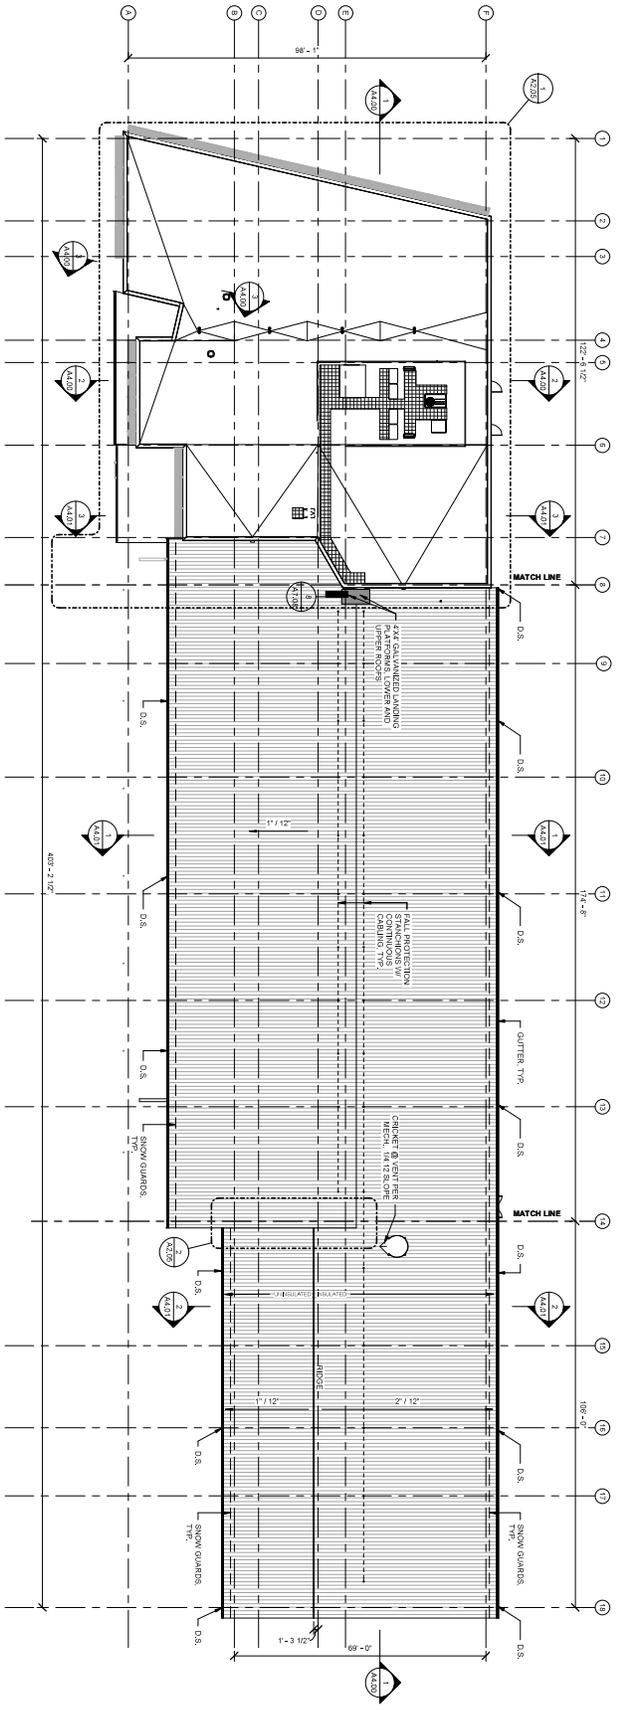

② OVERALL ROOF PLAN
1/16" = 1'-0"

BID SET			
SCALE: 1/16" = 1'-0"			
PSE PUYALLUP SERVICE CENTER			
PUGET SOUND ENERGY			
OVERALL FLOOR AND ROOF PLANS			
DATE: 06-15-16			
DRAWN BY:			
CHECKED BY:			
TITLE:			
A2.00			

